

OFF LICENCE



Licence No: 49D/OFF/50/2022

PURSUANT to the Sale and Supply of Alcohol Act 2012, **Provinus Limited** (the licensee) is authorised to sell and supply alcohol from the premises situated at **85 Ludlam Street, Seatoun, Wellington**, and known as **Pond Paddock Vineyard**, to any person for consumption off the premises.

Section 40 of the Act applies to this licence. The licensee is authorised to sell alcohol from (but not on) the premises and deliver it somewhere else.

CONDITIONS

The licence is subject to the following conditions:

1. Alcohol may be sold from the premises at any time on any day, and delivered somewhere else for consumption off the premises.
2. No alcohol is to be delivered from the premises on Good Friday, Easter Sunday or Christmas Day or before 1.00 pm on Anzac Day.
3. No alcohol is to be delivered to the buyer (or to any other person on the buyer's behalf) at any time between 11:00pm and 6:00am the following day, on any day of the week.
4. There must be a certificated manager properly appointed to the business by the licensee.
5. The licensee must follow the procedures set out in Regulation 14 of the Sale and Supply of Alcohol Regulations 2013 to ensure that neither the purchaser nor the person to whom alcohol is delivered is a minor.
6. The licensee must state the licensee's name, licence number and date the licence expires:
 - a. on every receipt issued for alcohol sold remotely;
 - b. in every catalogue, if alcohol is sold by remote sale using catalogues;
 - c. on the internet site, if alcohol is sold by remote sale using an internet site;
 - d. if alcohol is sold by remote sale using an internet site, the site must also display either a legible image of the licence, or a clearly identified link to such an image.

The premises are as set out on the plan submitted with the application and attached as Appendix 1.

Subject to the requirements of the Act relating to the payment of fees, and to the provisions of the Act relating to the renewal, suspension and cancellation of licences, this licence expires on:

24 December 2024

This licence replaces licence number 49D/OFF/276/2020 issued by the Wellington District Licensing Committee

Dated at Wellington, 30 March 2022


J Austin
Secretary District Licensing Committee
Wellington City Council



SR No: 475118

APPENDIX 1

novak+middleton

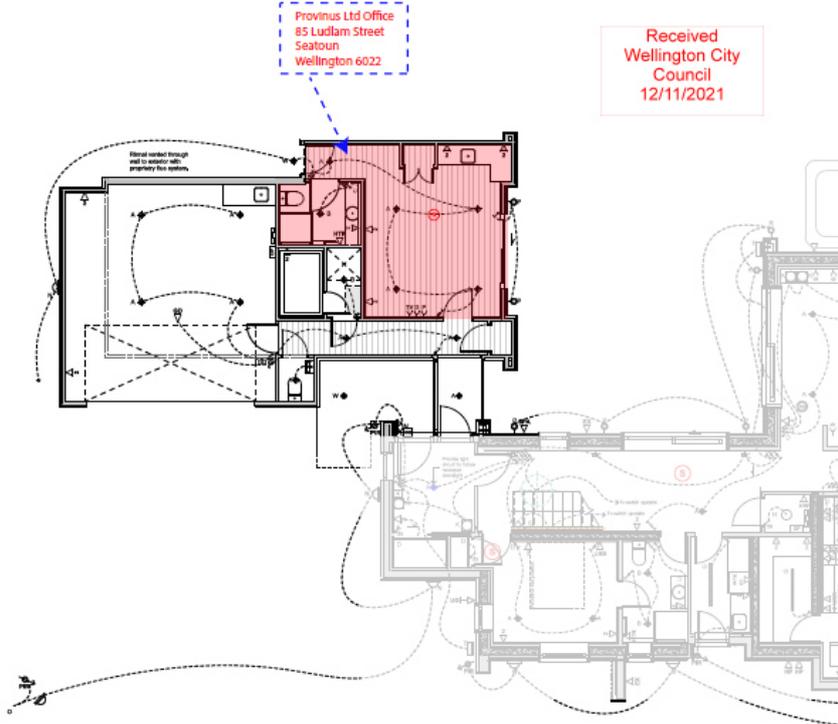

ELECTRICAL NOTES.

General:
 Electrical work to be carried out by a registered electrician in accordance with the Electrical Regulations 2011 and the New Zealand Electrical Code of Practice (NZECOP) 2011. All work must be carried out in accordance with the NZECOP 2011. All work must be carried out in accordance with the NZECOP 2011. All work must be carried out in accordance with the NZECOP 2011.

Make power supply:
 Provide 3 phase 400V 50Hz supply to distribution board.

Isolation of switches, outlets and lights:
 Confirm that light switch and power point locations on site are suitable for installation. All work must be carried out in accordance with the NZECOP 2011.

Applications and fittings:
 Allow for installation of applications as shown on drawings, including location of power to various applications.

Provide & wire circuit breakers to (3) 250A main circuit breakers to be installed by light switch.

Audio Visual:
 All AV equipment to be installed, unless otherwise specified, shall be installed in accordance with the manufacturer's instructions.

Phone and Data:
 Provide network cabling connections from the main network room to all workstations and servers. Provide network cabling to all workstations and servers.

Security System:
 Provide network cabling to all security cameras and sensors. Provide network cabling to all security cameras and sensors.

Medical Ventilation System:
 Provide power supply for ventilation system as required. Provide power supply for ventilation system as required.

Lighting Fitting Legend:
 All light fittings to be installed in accordance with the manufacturer's instructions. Provide power supply for all lighting fittings. Provide power supply for all lighting fittings.

ELECTRICAL LEGEND:
 Distribution board/Miniature board
 Underground cabling entry point
 Approved service meter to be installed in accordance with the manufacturer's instructions. Provide and install by others.
 Control panel for selected switch/heating
 Security system keypad
 Telephone socket
 Data network outlet
 Ventilation outlet
 Data patch panel
 Client supplied ceiling fan
 Client supplied home cinema ceiling speaker, unless noted, ceiling supplied by client.
 Specialist terminal, unless noted to be home theatre system, unless provided by client. Locate on site with client to determine final location.

Lighting Fitting Legend:
 All light fittings to be installed in accordance with the manufacturer's instructions. Provide power supply for all lighting fittings. Provide power supply for all lighting fittings.

Project: Alemagna Garage For Client's Use At 85 Ludlam Street, Wellington	DATE: 11/07/2019 DESIGNER: Novak+Middleton CLIENT: Provincus Ltd	Scale: 1:50 Discipline: Electrical Plan Project Number: 1505 Sheet Number: B104
---	---	--

WCC Approved plans SR443063 : 11/07/2019 A copy must be kept on site

